



Floor Plan

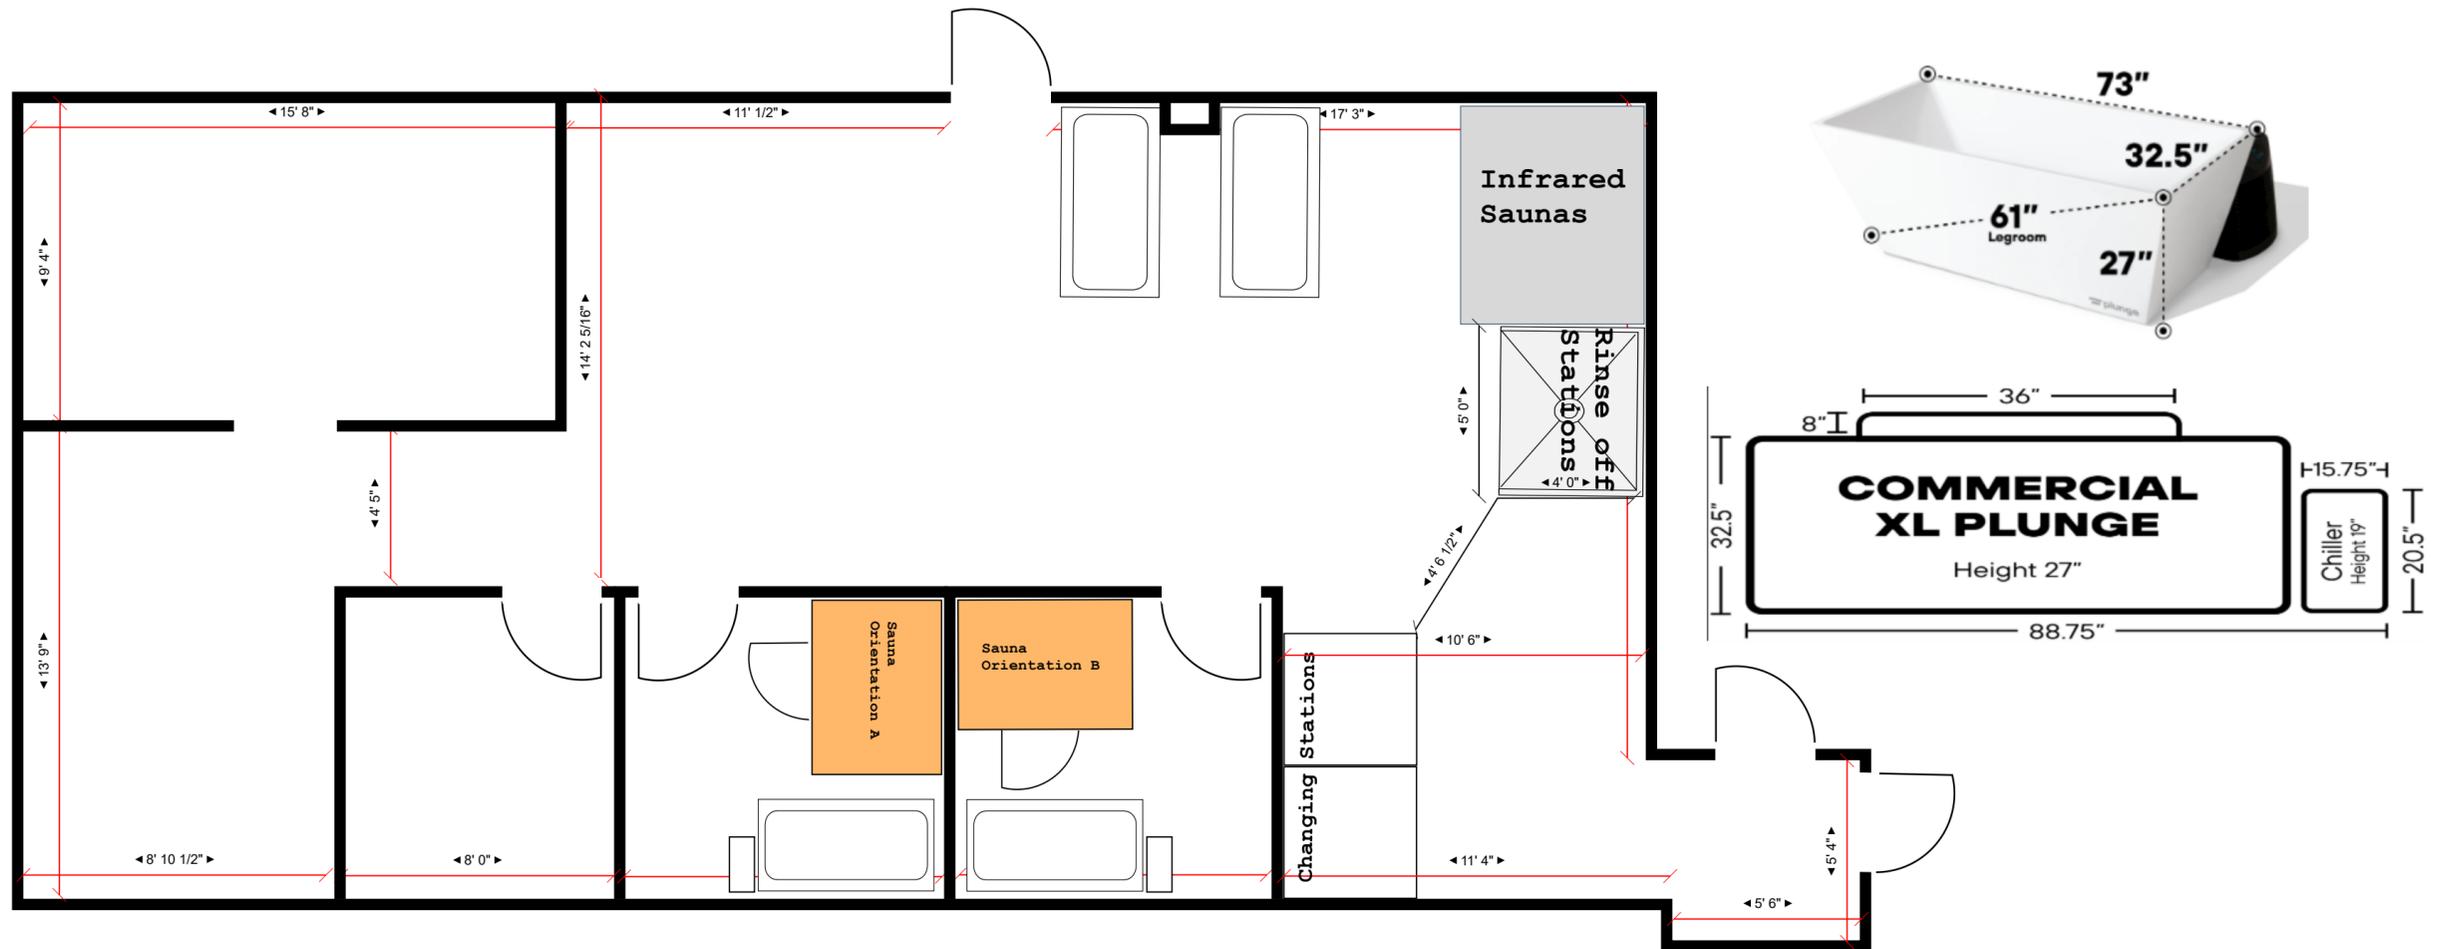

Site:	405 Anglers Drive, Steamboat	Drawing:	Rev 101	Project:	Rev 101	Drawn:	R Goncalves	Notes:	Urban Remodz 3550 S Downing St 303 801 0070
Title:	Revolve	Scale:	1/4":1'0"	Date:	07/01/2024	Rev:			


Electrical Plan


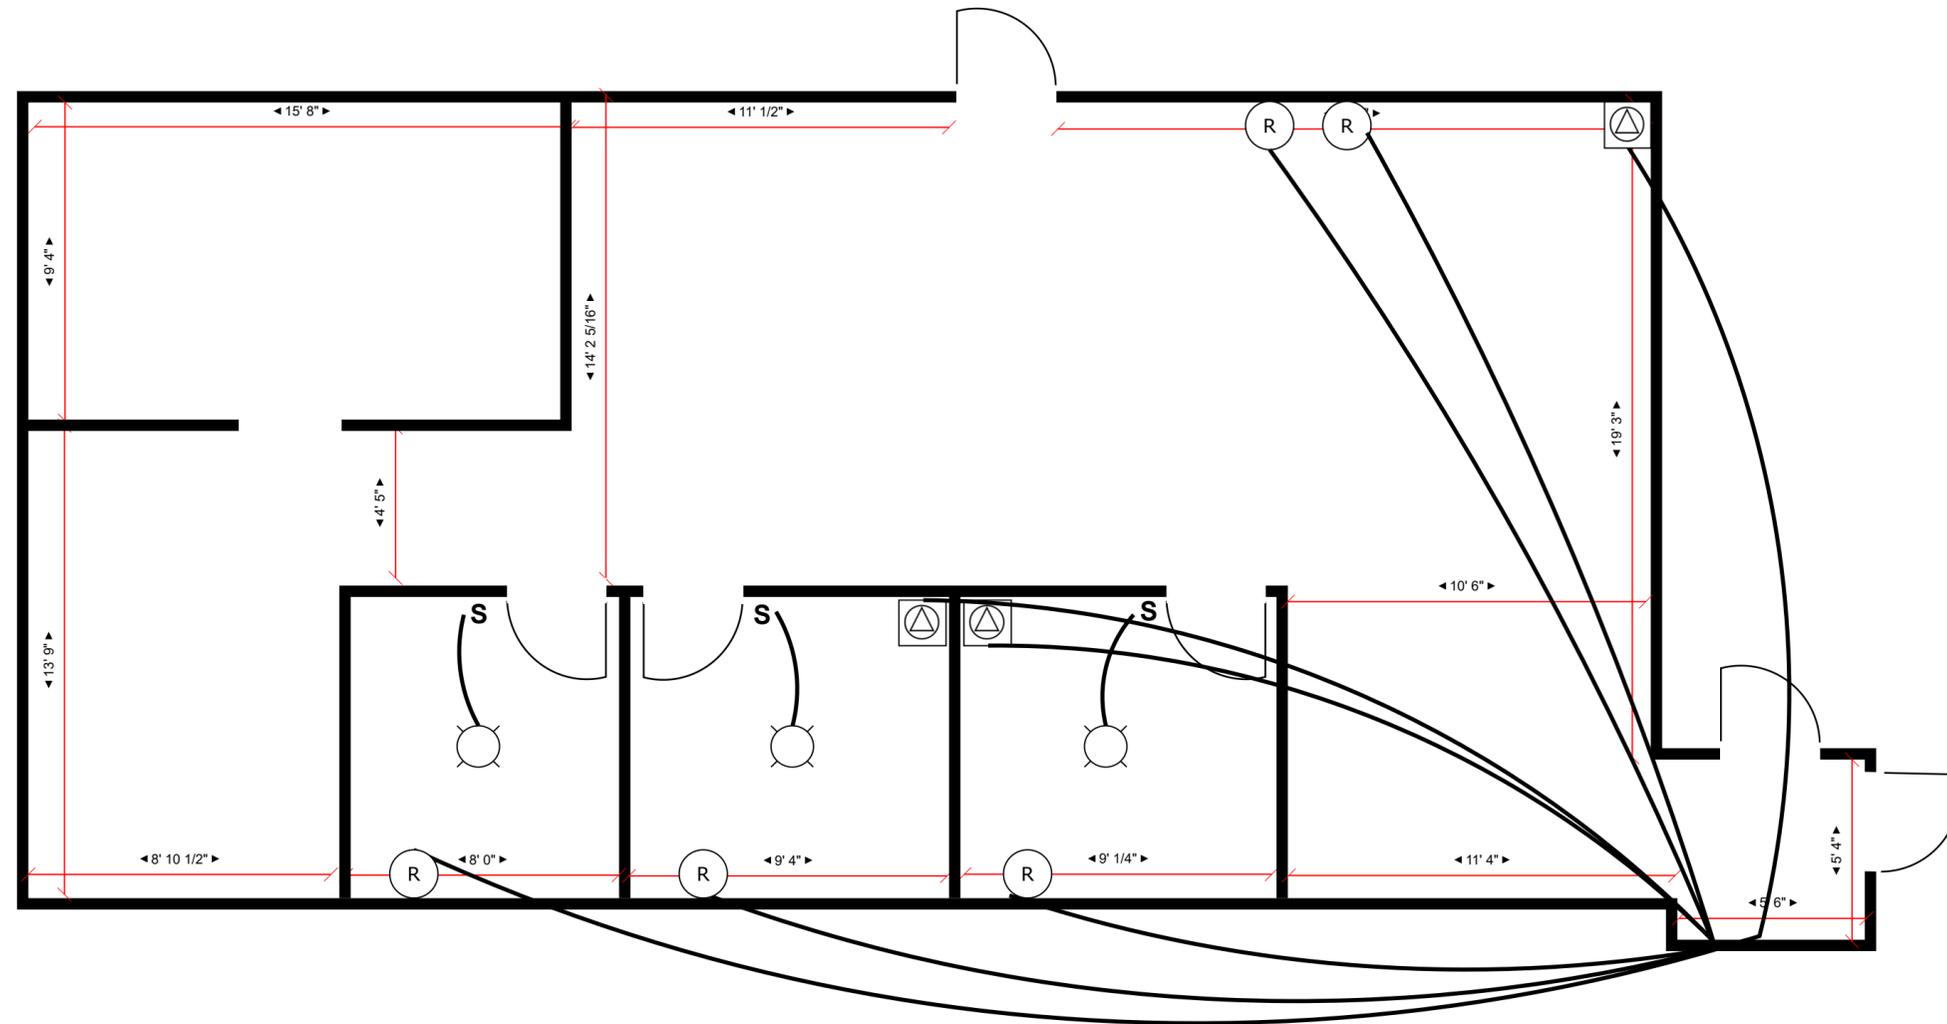


- △ SE 40 amp Equipment 8/3 wire Dedicated
- △ Therapy Room 1 & 2 [20 amp Equipment 12/2 wire Dedicated GFCI]
- R Therapy Room [15 amp Equipment 12/2 wire Dedicated GFCI]
- S Added light switch with existing electrical for specified room isolation

Site: 405 Anglers Drive - Unit D, Steamboat	Drawing: Rev 102	Project: Rev 102	Drawn: R Goncalves	Notes:
Title: Revolve	Scale: 1/4" : 1'0"	Date: 07/01/2024	Rev:	Urban Remodz 3550 S Downing St Englewood 303 801 0070

  
Plumbing & DWV

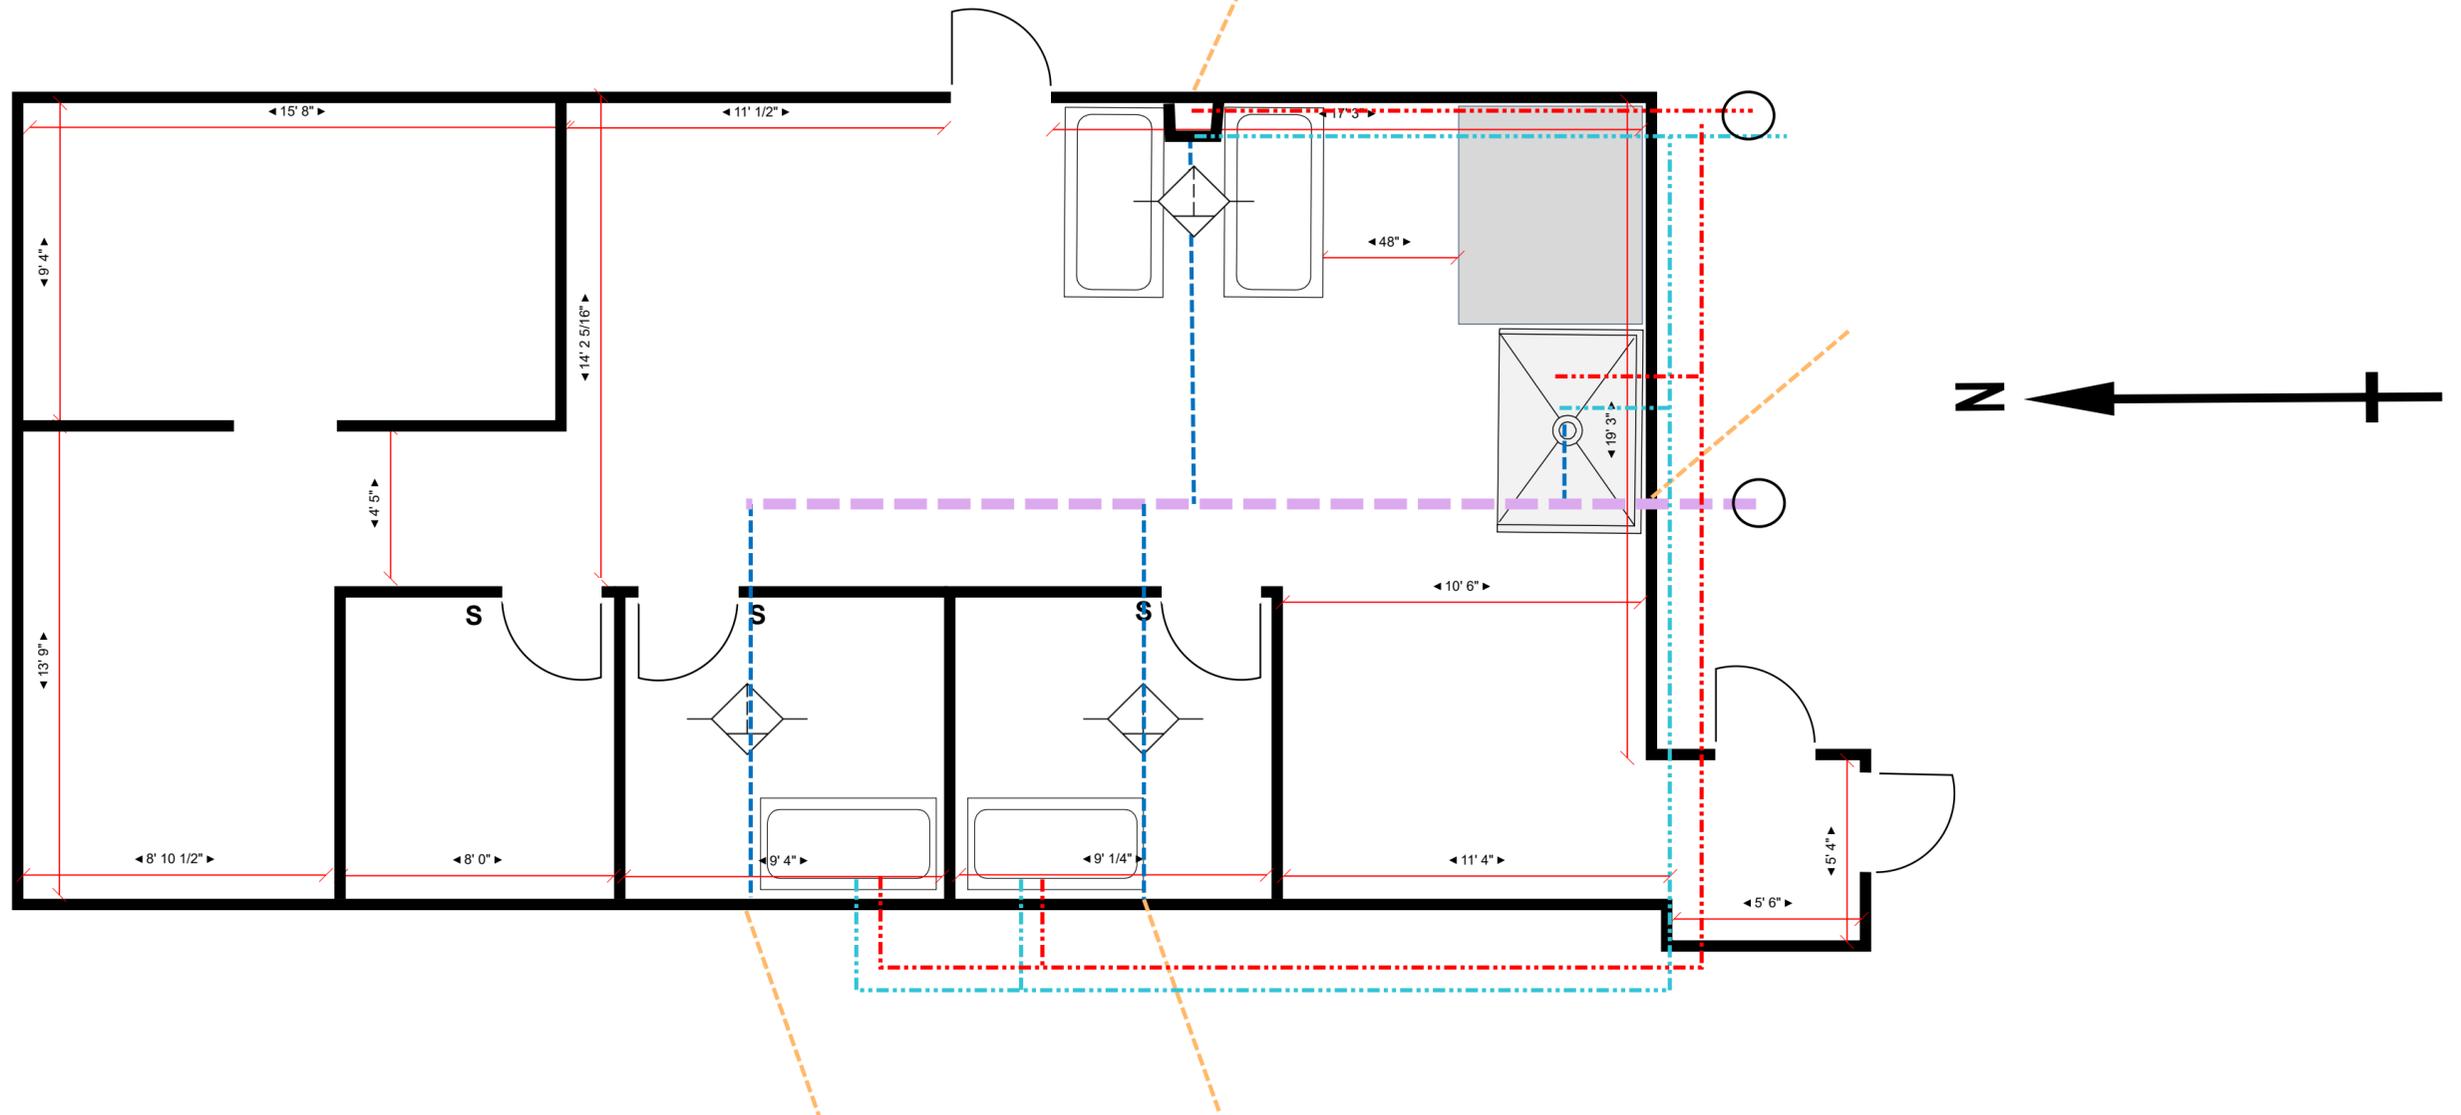

-  Floor Drain 2" PVC P-Trap as per code
-  3" to 4" PVC Main Evacuation Piping, Start of DWV
-  2" Floor Drain PVC pipe 2" P-Trap as per Code by Drains
-  2" Venting to be added to existing Vent System centered vent in ceiling Area
-  Existing Water Line supply
-  Hot & Cold Water Supply

Site:	405 Anglers Drive Unit D, Steamboat Springs	Drawing:	Rev-103	Project:	REV-103	Drawn:	R Goncalves	Notes:	
Title:	Revolve	Scale:	1/4" : 1'0"	Date:	07/01/2024	Rev:			Urban Remodz 3550 S Downing St Englewood, CO, 80113 303 801 0070

Plumbing & DWV

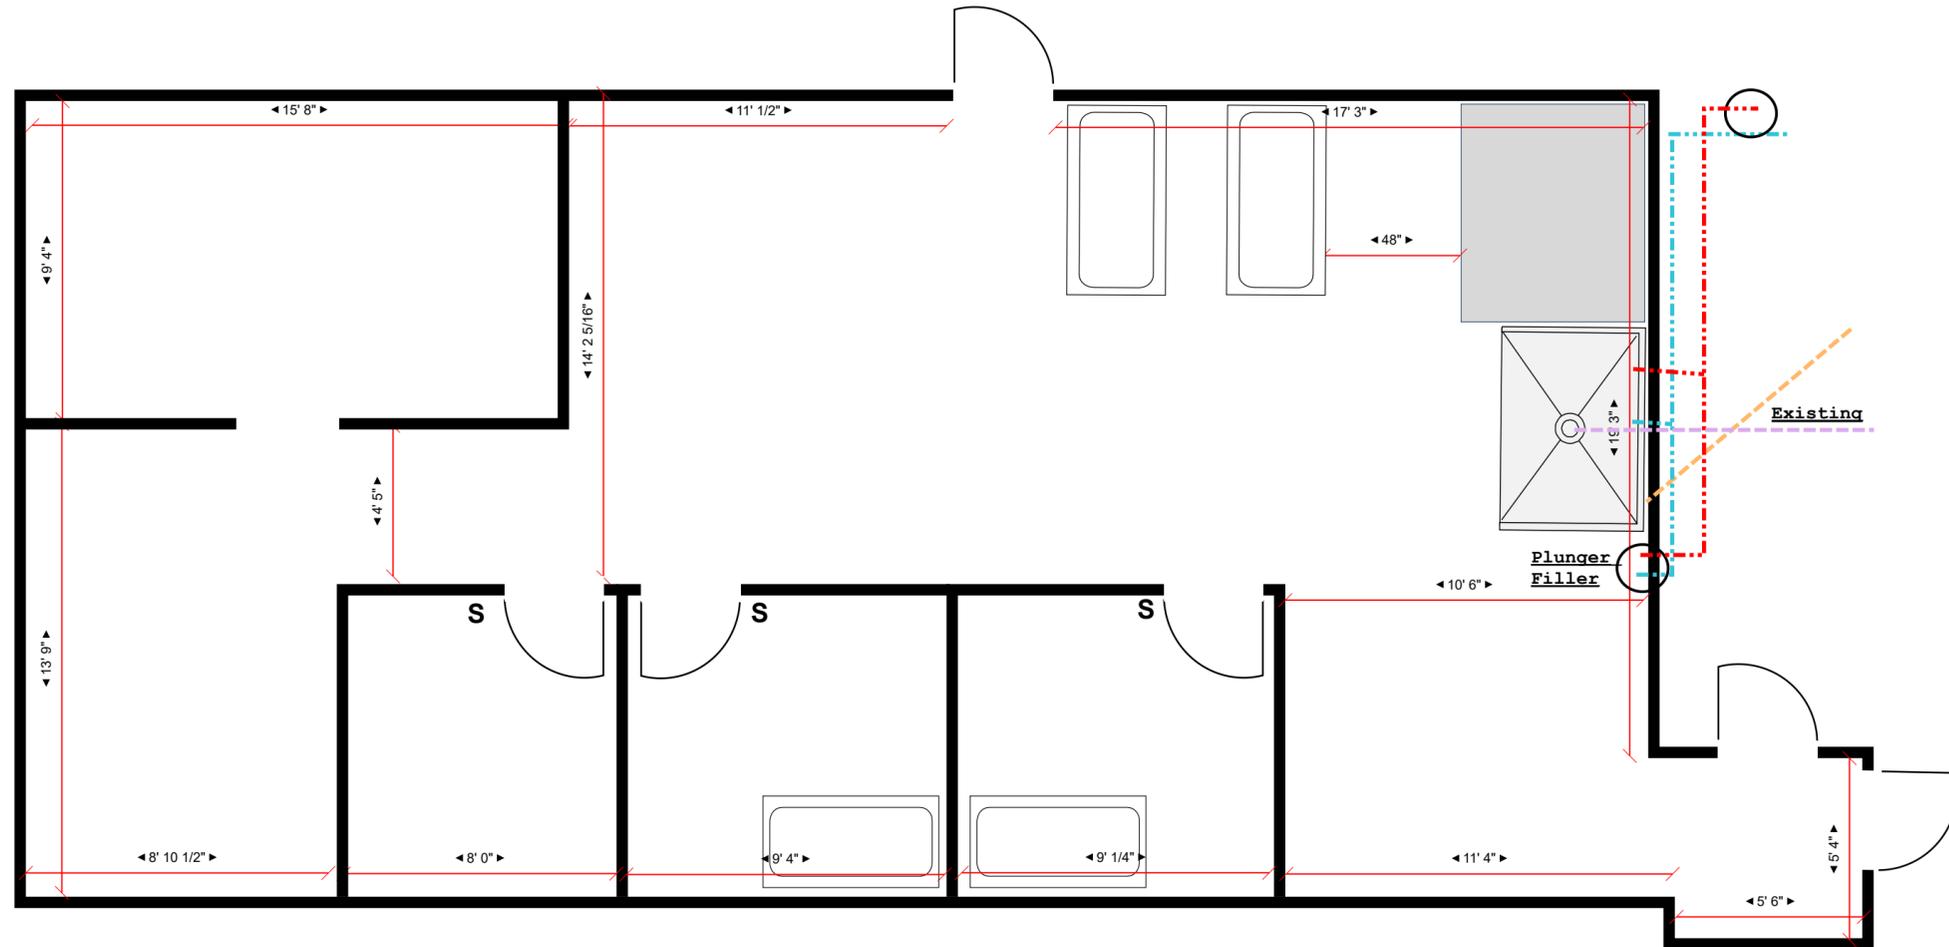

Site:	405 Anglers Drive Unit D, Steamboat Springs	Drawing:	Rev-103	Project:	REV-103	Drawn:	R Goncalves	Notes:	Urban Remodz 3550 S Downing St Englewood, CO, 80113 303 801 0070
Title:	Revolve	Scale:	1/4" : 1' 0"	Date:	07/01/2024	Rev:			