CABINETRY SPECIFICATION	ONS KITCHEN PERIMETER	ISLAND	APPLIANCES	MAKE	MODEL	FINISH
COLLECTION: CONSTRUCTION: DOOR STYLE: DRAWER STYLE: WOOD SPECIES: FINISH: CARCASS: DRAWER BOX: DRAWER HARDWARE: DOOR HINGES: DOOR HINGE FINISH: DECORATIVE HARDWARE:	BENTWOOD FRAMELESS NOUVEAU NOUVEAU WALNUT CUSTOM-STAIN PRE-FIN. MAPLE PLY SOLID WOOD FULL EXT. SOFT CLOSE EURO CONCEALED N/A INTEGRATED ALUMINUM	BENTWOOD FRAMELESS BONN BONN KNOTTY WALNUT CUSTOM-STAIN & GLAZE PRE-FIN. MAPLE PLY SOLID WOOD FULL EXT. SOFT CLOSE EURO CONCEALED N/A	30" REFRIGERATOR 48" DUEL FUEL RANGE RED KNOB SET CUSTOM HOOD HOOD INSERT 24" FREEZER DRAWERS 60cm COFFEE SYSTEM 30" COFFEE TRIM KIT 60cm COMBI STEAM OVEN 30" STEAM OVEN TRIM KIT 30" WINE STORAGE WINE LOCK KIT 60cm DISHWASHER	SUB ZERO WOLF WOLF - BEST SUB ZERO MIELE MIELE MIELE MIELE SUB ZERO SUB ZERO MIELE	IC30RRH DF486GLP 804370 - CP57IQT489SB ID24FI CVA6800SS EBA6808MC DGC68051XLSS EBA6808SS IW30ARLH 7028773 PG8133SCVI208	CABINET PANEL SS RED SS SS CABINET PANEL SS SS SS CABINET PANEL CABINET PANEL - CABINET PANEL
**ANY CASE GOOD OR CASE MUST BE SEALED WITH (2) C BASED POLYURETHANE BEFO	OATS OF CLEAR WATER		**NOTE WINE STORAGE NEEDS	6 TO BE HIGH ALT	ITUDE GLASS**	
			PLUMING FIXTURES  MAIN FAUCET  MAIN SINK  AIR SWITCH	GALLEY I	WS4S WH 316 L	SH METAL STAINLESS STEI METAL

PLUMING FIXTURES	MAKE	MODEL	FINISH
MAIN FAUCET MAIN SINK AIR SWITCH	GALLEY GALLEY GALLEY	IWT D GSS IWS4S WH IDS 1 GSS	GUN METAL 316 L STAINLESS STEEL GUN METAL
BOTTOM GRATES DIPSOSAL FLANGE/BASKET 18" UPPER DECK 12 UPPER DECK UTENSIL CADDY	GALLEY GALLEY GALLEY GALLEY GALLEY	BG4S2SS GDRNMSS UD-18-1WH UD-12-1WH UD064	STAINELESS STEEL STAINSLESS STEEL WHITE WHITE **NOTE - ACCESSORY COLORS TO BE VERIFIED AFTER ISLAND STONE IS SELECTED.**



© 2014 DESIGN PLANS ARE PROVIDED FOR THE FAIR USE BY THE CLIENT OR HIS AGENT IN COMPLETING THE PROJECT AS LISTED IN THIS CONTRACT. DESIGN PLANS REMAIN THE PROPERTY OF BENTWOOD OF CHICAGO AND CANNOT BE USED OR REUSED WITHOUT PERMISSION.


ROSENSTEIN RESIDENCE 2410 SKI TRAIL LANE STEAMBOAT SPRINGS, CO 80487 DATE/REVISIONS:


2.19.19 5.15.20
2.28.19 7.23.21
3.6.19
4.8.19
7.1.19
7.15.19

PRODUCTION DRAWINGS

DESIGNER: STEVE KARP
DRAWN BY: SS
SCALE: 1/2"=1'-0"

ROOM: KITCHEN

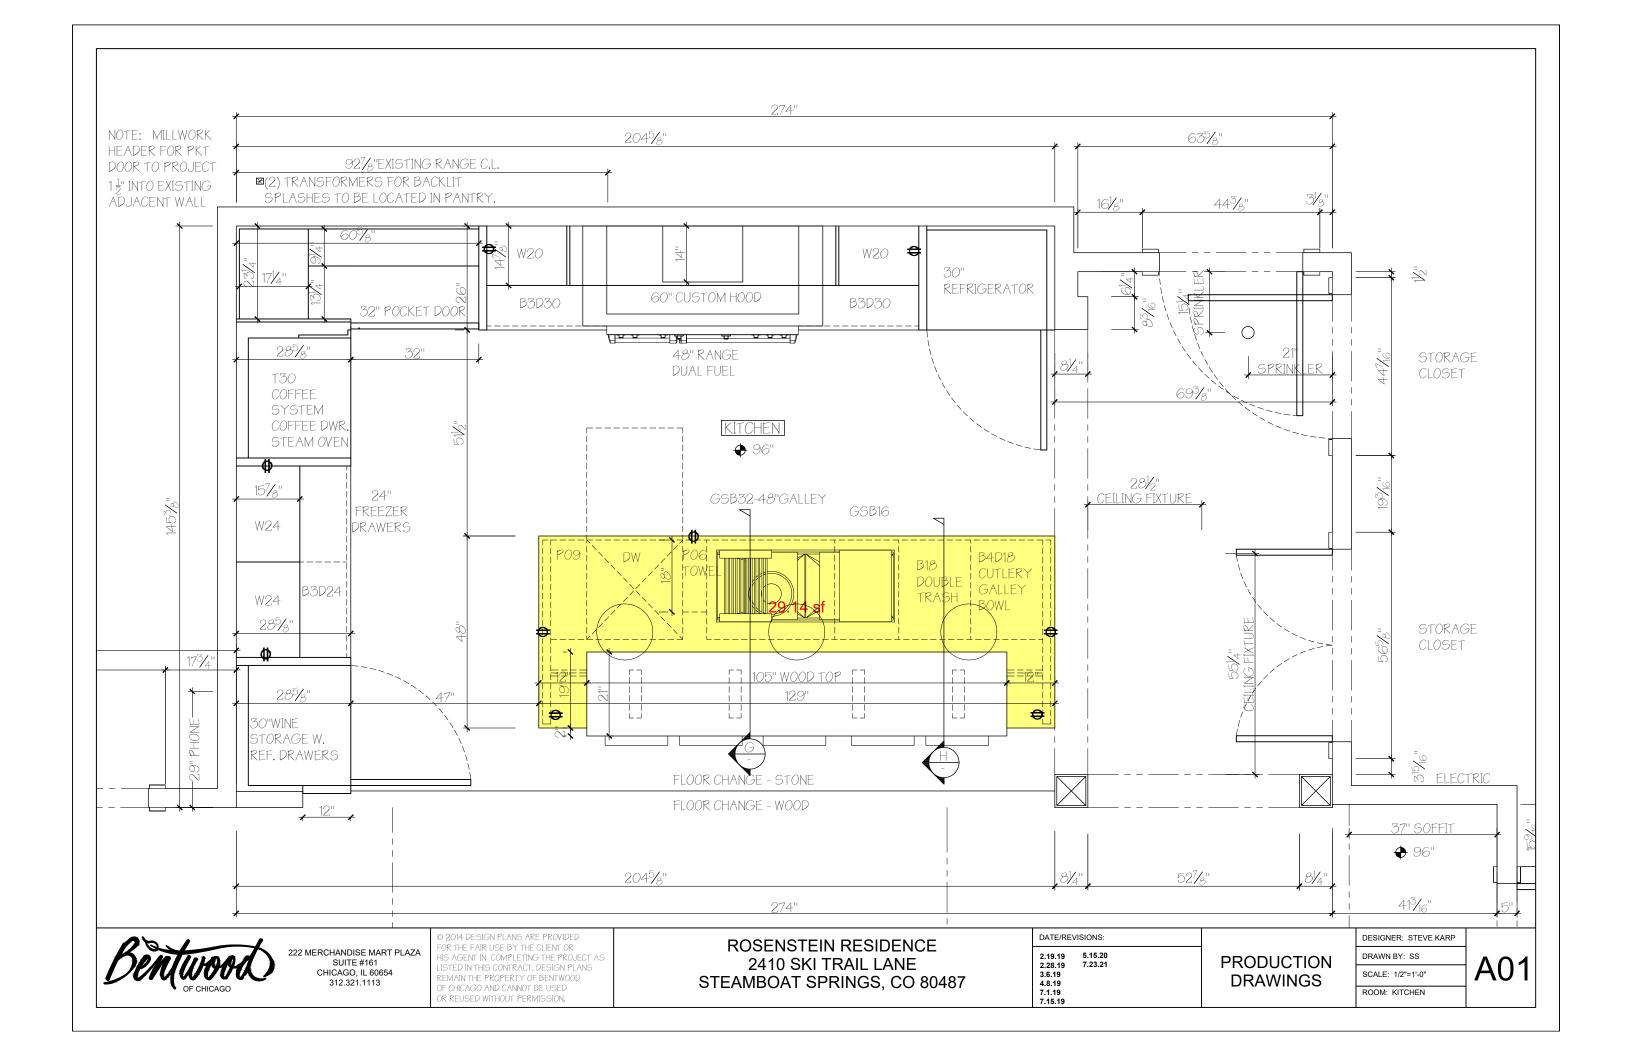

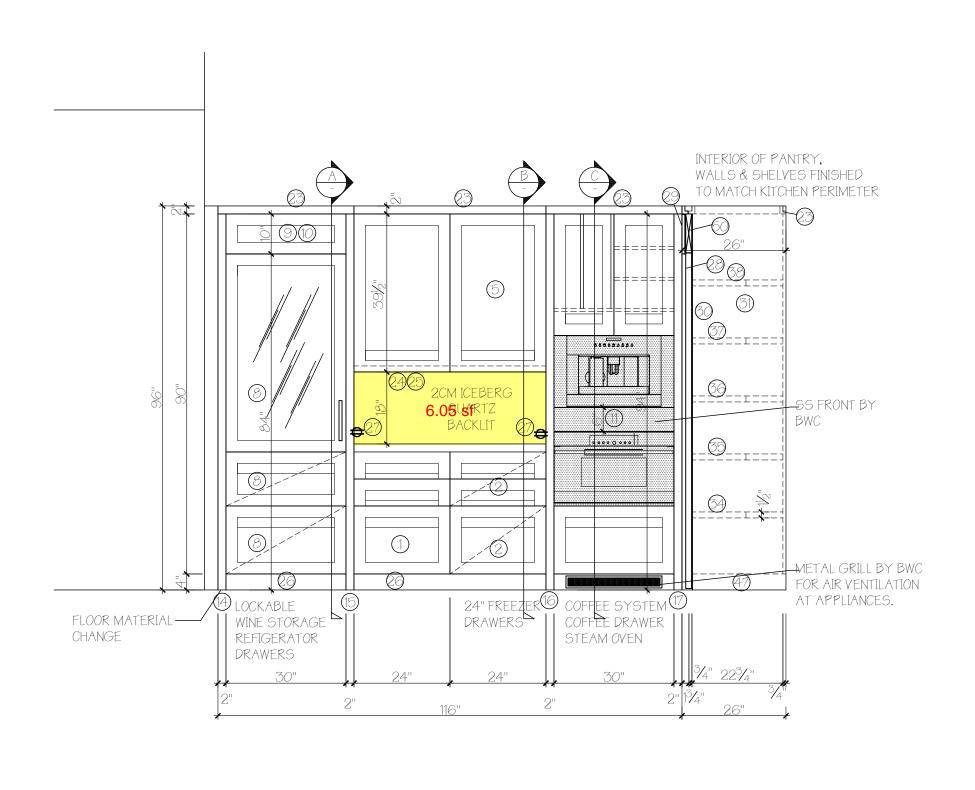



© 2014 DESIGN PLANS ARE PROVIDED FOR THE FAIR USE BY THE CLIENT OR HIS AGENT IN COMPLETING THE PROJECT AS LISTED IN THIS CONTRACT. DESIGN PLANS REMAIN THE PROPERTY OF BENTWOOD OF CHICAGO AND CANNOT BE USED OR REUSED WITHOUT PERMISSION.


ROSENSTEIN RESIDENCE 2410 SKI TRAIL LANE STEAMBOAT SPRINGS, CO 80487 DATE/REVISIONS:

2.19.19 5.15.20
2.28.19 7.23.21
3.6.19
4.8.19
7.1.19
7.1.5.19

PRODUCTION DRAWINGS

DESIGNER: STEVE KARP
DRAWN BY: SS

SCALE: 1/2"=1"-0"
ROOM: KITCHEN

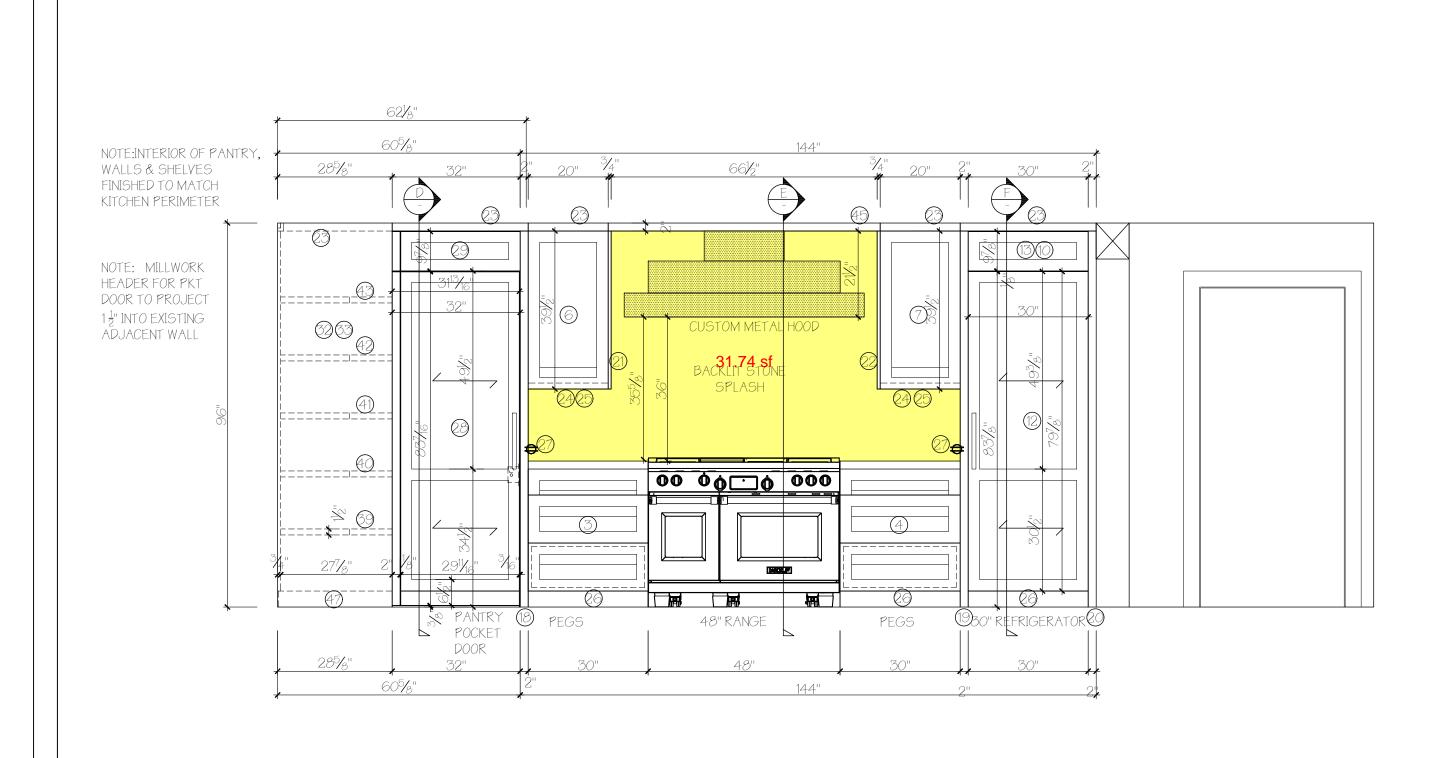



© 2014 DESIGN PLANS ARE PROVIDED FOR THE FAIR USE BY THE CLIENT OR HIS AGENT IN COMPLETING THE PROJECT AS LISTED IN THIS CONTRACT. DESIGN PLANS REMAIN THE PROPERTY OF BENTWOOD OF CHICAGO AND CANNOT BE USED OR REUSED WITHOUT PERMISSION.

ROSENSTEIN RESIDENCE 2410 SKI TRAIL LANE STEAMBOAT SPRINGS, CO 80487 DATE/REVISIONS:


2.19.19 5.15.20
2.28.19 7.23.21
3.6.19
4.8.19
7.1.19
7.15.19

PRODUCTION DRAWINGS

DESIGNER: STEVE KARP
DRAWN BY: SS
SCALE: 1/2"=1'-0"

ROOM: KITCHEN

\_\_A03

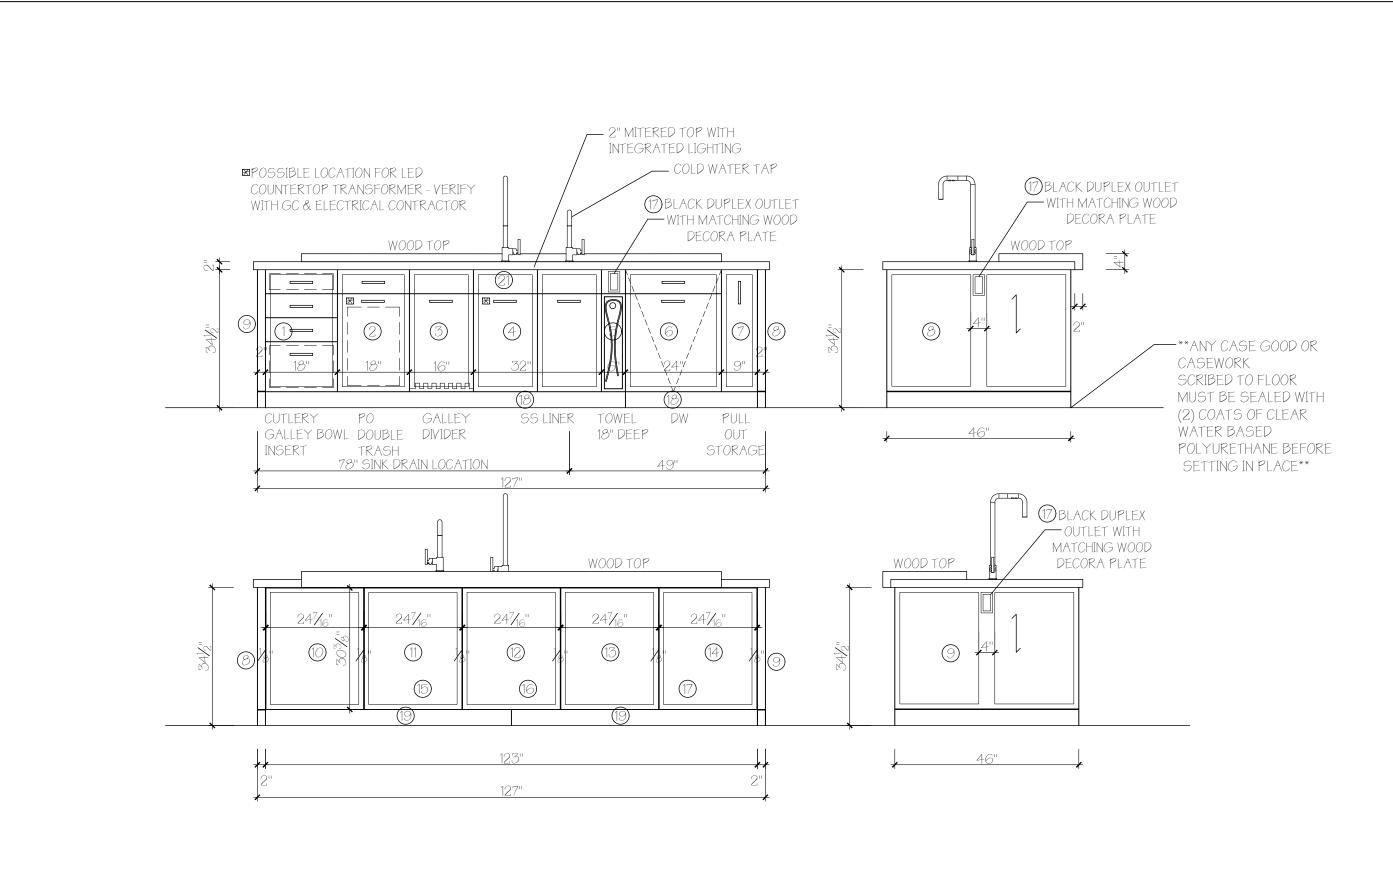



© 2014 DESIGN PLANS ARE PROVIDED FOR THE FAIR USE BY THE CLIENT OR HIS AGENT IN COMPLETING THE PROJECT AS LISTED IN THIS CONTRACT. DESIGN PLANS REMAIN THE PROPERTY OF BENTWOOD OF CHICAGO AND CANNOT BE USED OR REUSED WITHOUT PERMISSION.


ROSENSTEIN RESIDENCE 2410 SKI TRAIL LANE STEAMBOAT SPRINGS, CO 80487 DATE/REVISIONS:


2.19.19 5.15.20
2.28.19 7.23.21
3.6.19
4.8.19
7.1.19
7.15.19


PRODUCTION DRAWINGS


DESIGNER: STEVE KARP
DRAWN BY: SS
SCALE: 1/2"=1'-0"


ROOM: KITCHEN

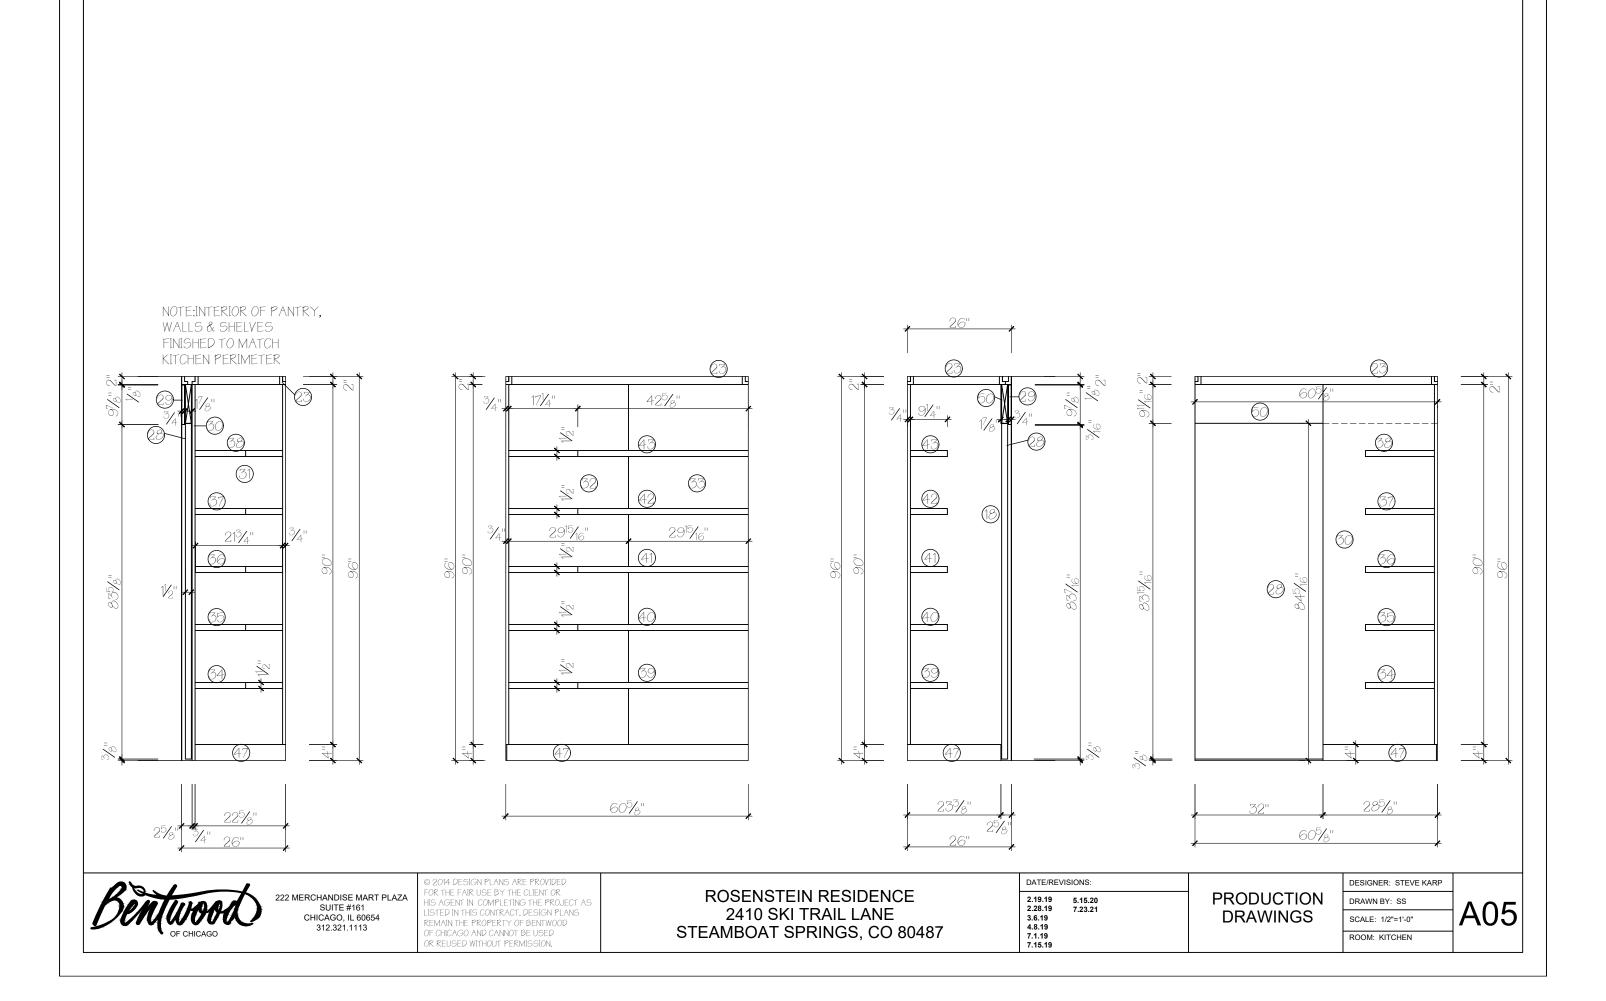

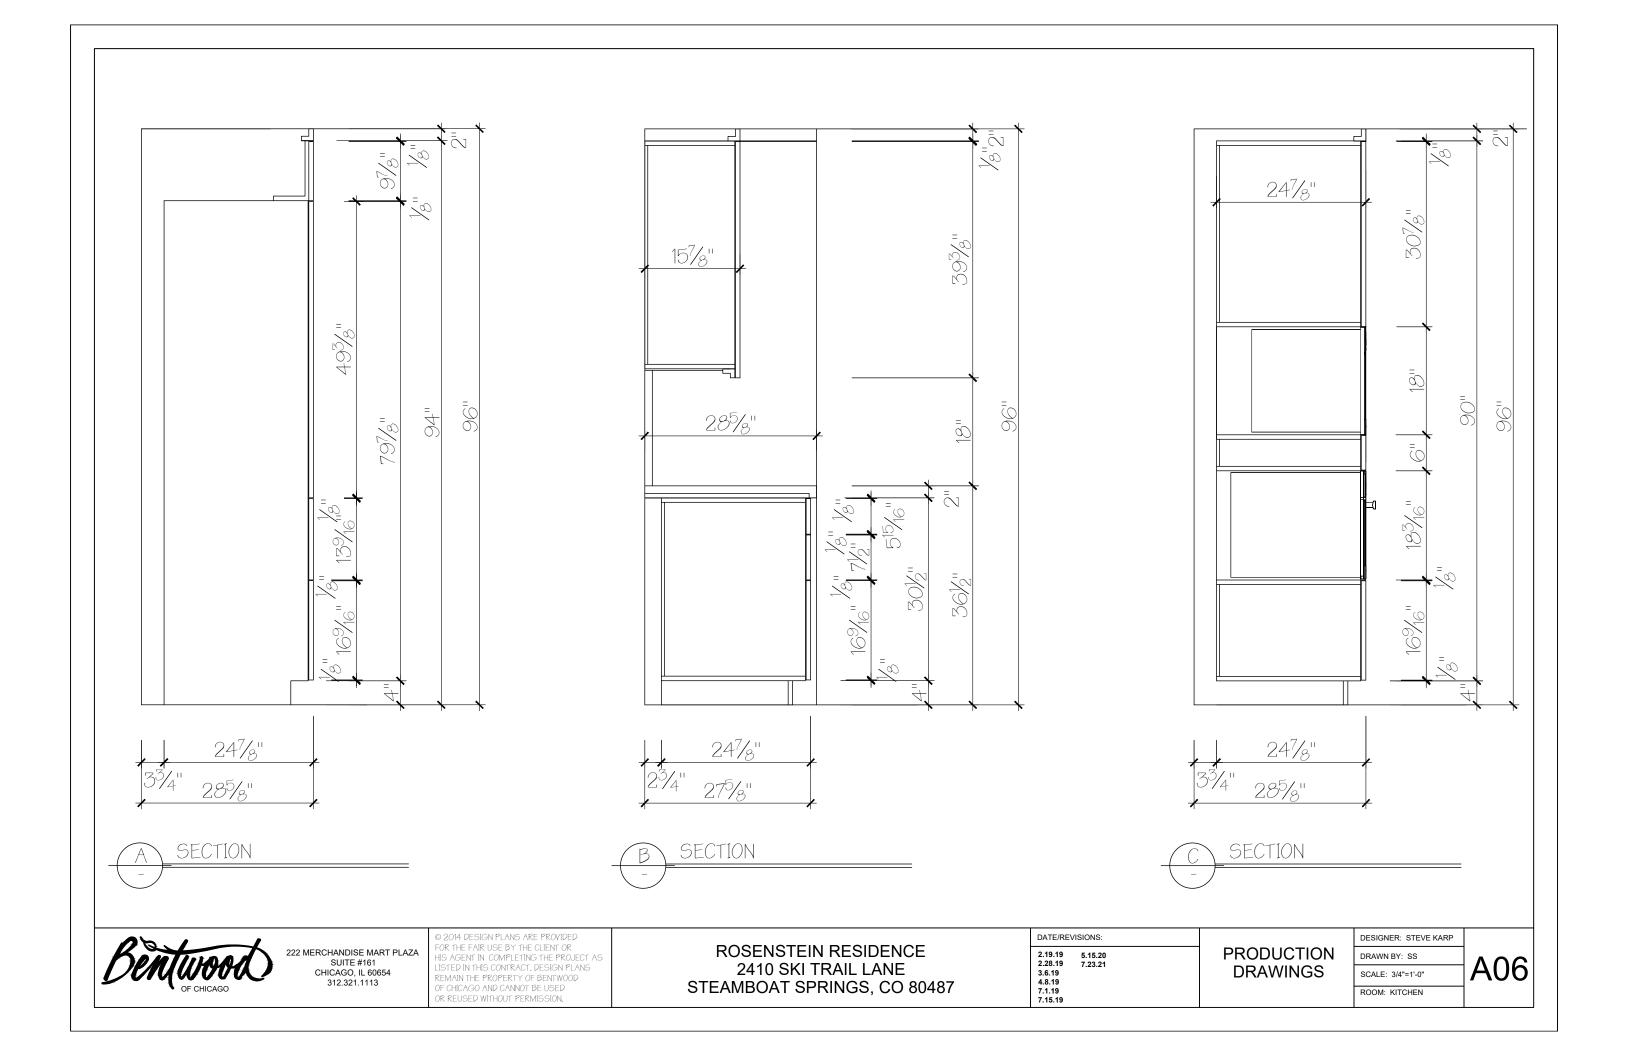

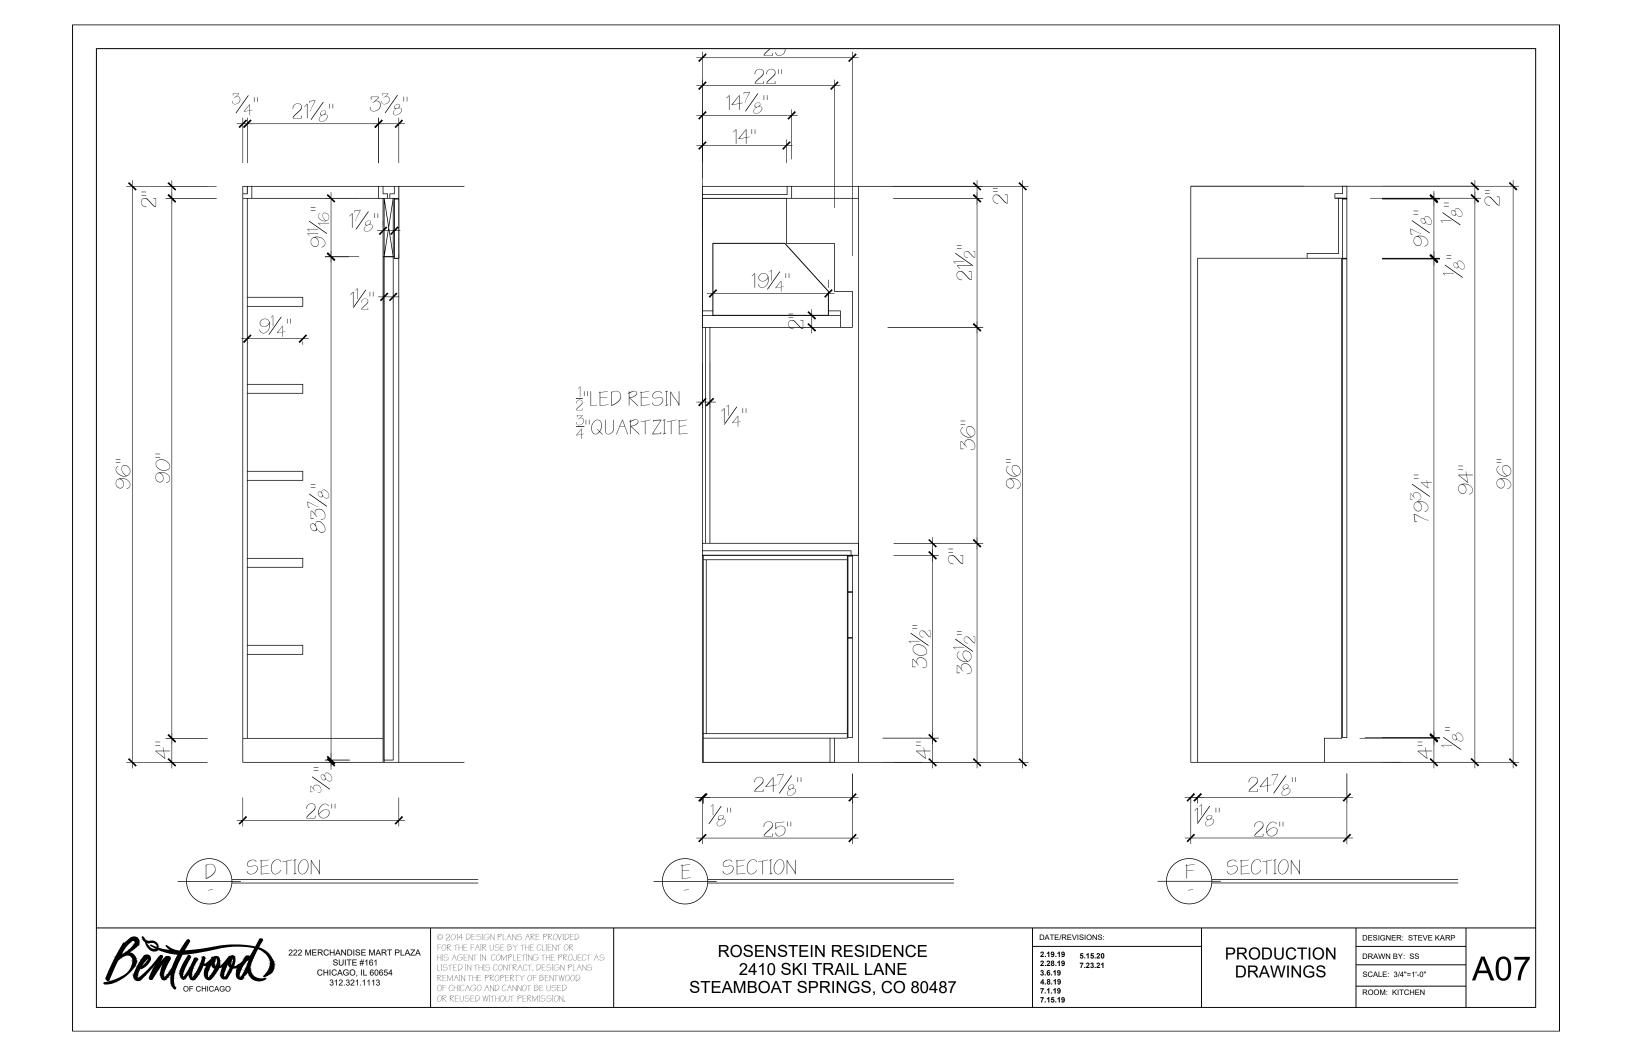

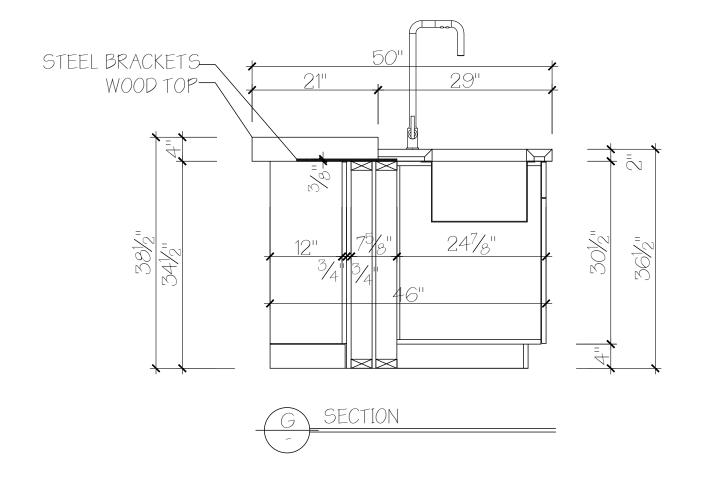

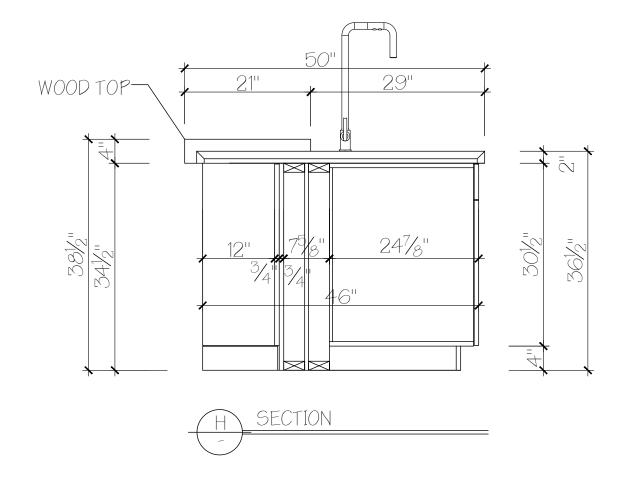



© 2014 DESIGN PLANS ARE PROVIDED FOR THE FAIR USE BY THE CLIENT OR HIS AGENT IN COMPLETING THE PROJECT AS LISTED IN THIS CONTRACT. DESIGN PLANS REMAIN THE PROPERTY OF BENTWOOD OF CHICAGO AND CANNOT BE USED OR REUSED WITHOUT PERMISSION.

ROSENSTEIN RESIDENCE 2410 SKI TRAIL LANE STEAMBOAT SPRINGS, CO 80487 DATE/REVISIONS:

2.19.19 5.15.20
2.28.19 7.23.21
3.6.19
4.8.19
7.1.19
7.15.19

PRODUCTION DRAWINGS

DESIGNER: STEVE KARP

DRAWN BY: SS

SCALE: 3/4"=1'-0"


ROOM: KITCHEN



\*ALL FIXTURES & SWITCHES ARE PROPOSED
\*STRUCTURAL & MECHANICAL TAKE PRECEDENT
\*REVIEW WITH HOMEOWNER PRIOR TO WORK
STARTING

\*LOCAL ELECTRIC CODES TO BE FOLLOWED
\*DEVIATION FROM PROPOSED PLAN REQUIRES
CLIENT NOTIFICATION WITH ALTERNATE SOLUTION.

4" LED CAN LIGHTS	<b>(</b>
J BOX FOR FUTURE PENDANTS	B
SINGLE SWITCH	\$
THREE WAY SWITCH &/OR DIMMER	\$ <sub>3 D</sub>
UNDER CAB, LIGHT	
SINGLE TOGGLE SWITCH & OUTLET	\$ <b>ф</b>

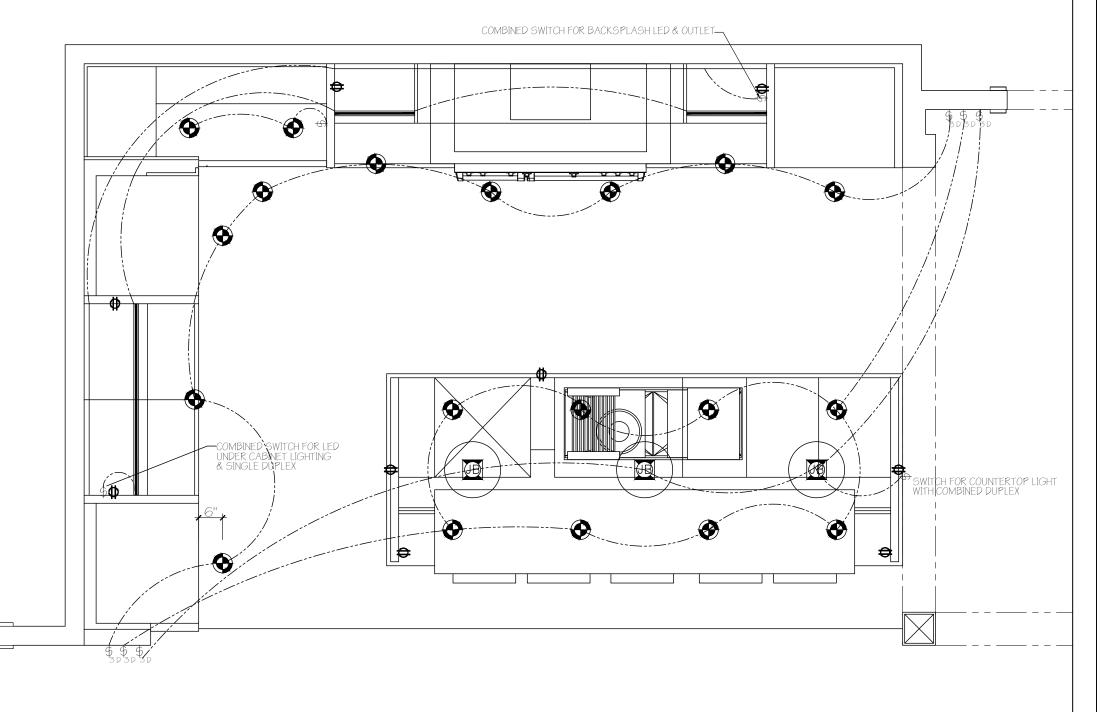



222 MERCHANDISE MART PLAZA SUITE #161 CHICAGO, IL 60654 312.321.1113 © 2014 PESIGN PLANS ARE PROVIDED FOR THE FAIR USE BY THE CLIENT OR HIS AGENT IN COMPLETING THE PROJECT AS LISTED IN THIS CONTRACT. DESIGN PLANS REMAIN THE PROPERTY OF BENTWOOD OF CHICAGO AND CANNOT BE USED OR REUSED WITHOUT PERMISSION.

ROSENSTEIN RESIDENCE 2410 SKI TRAIL LANE STEAMBOAT SPRINGS, CO 80487 DATE/REVISIONS:

2.19.19 5.15.20
2.28.19 7.23.21
3.6.19
4.8.19
7.1.19
7.15.19

PROPOSED LIGHTING PLAN DESIGNER: STEVE KARP

DRAWN BY: SS

SCALE: 1/2"=1'-0"

ROOM: KITCHEN