


DEMO WORK

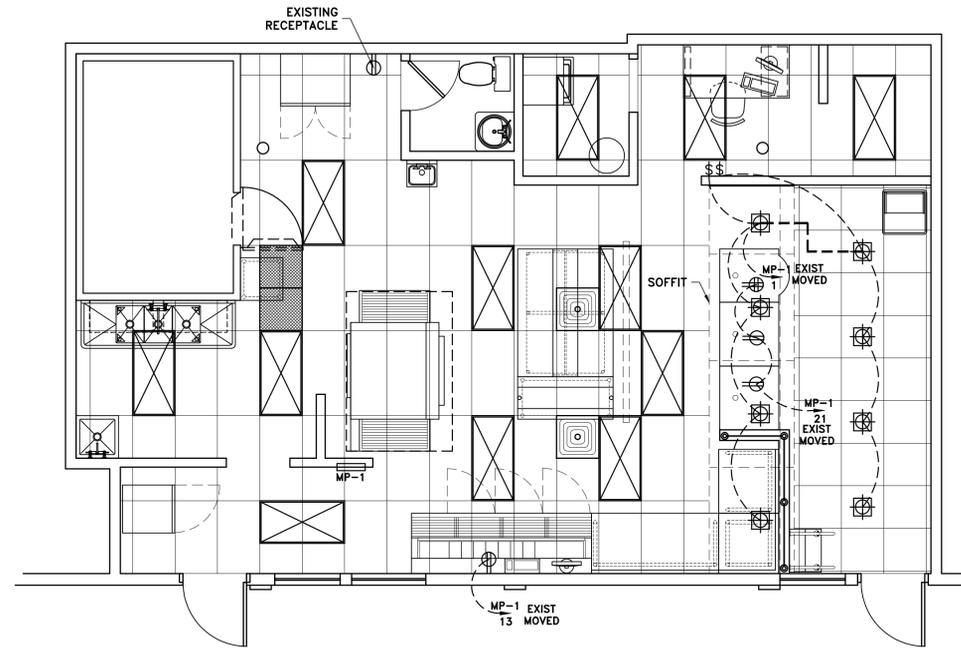


ELECTRICAL

KEY TO SYMBOLS

	DUPLEX RECEPTACLE
	GRND FAULT INTERRUPTER PROTECTED
	OUTLET W/ ISO GND. COMPUTER CIRCUIT
	QUADRAPLEX OUTLET
	QUADRAPLEX OUTLET W/ ISO GND. COMPUTER CIRCUIT
	JUNCTION BOX
	TELEPHONE JACK RECEPTACLE
	DATA JACK RECEPTACLE
	RECESSED LIGHT 14W LED LAMP (10)
	2X4 LIGHT FIXTURE (EXISTING)
	SWITCH
	DISCONNECT


NOTE:
THIS ELECTRICAL LAYOUT IS ONLY A SUGGESTION AND MAY CHANGE SLIGHTLY ON SITE

NOTE:
ONLY NEW OR RELOCATED CIRCUITS ARE SHOWN

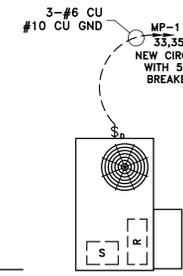

EQUIPMENT SCHEDULE

MARK	QTY.	E&S PART NO.	ITEM DESCRIPTION
1	2	BY OWNER	6 FT STAINLESS STEEL DOUGH COUNTER 10" BACK SPLASH
2	1	PC 22139	UNIVERSAL CORNER WITH LEGS
3	1	EXISTING	3 FT STAINLESS STEEL DOUGH COUNTER 10" BACK SPLASH
4	1	EXISTING	MAKELINE 8'-6"
5	2	284001	SALE COUNTER 36" W/ ORDER TERNINAL
6	1	284004	PICKUP COUNTER
7	1	EXISTING	60" ROUTE STAND - HEAT RACK
8	1	EXISTING	6 FT CUT TABLE W/ OVER SHELF PC 320804
9	1	BY OWNER	GLASS WINDOW SNEEZE GUARD
10	1	BY OWNER	CHILD STAIRS 2 STEPS W/ HANDRAIL
11	1	---	MENU BOARDS
12	1	EXISTING	TRASH RECEPTACLE
13	1	EXISTING	OVEN AND HOOD
14			

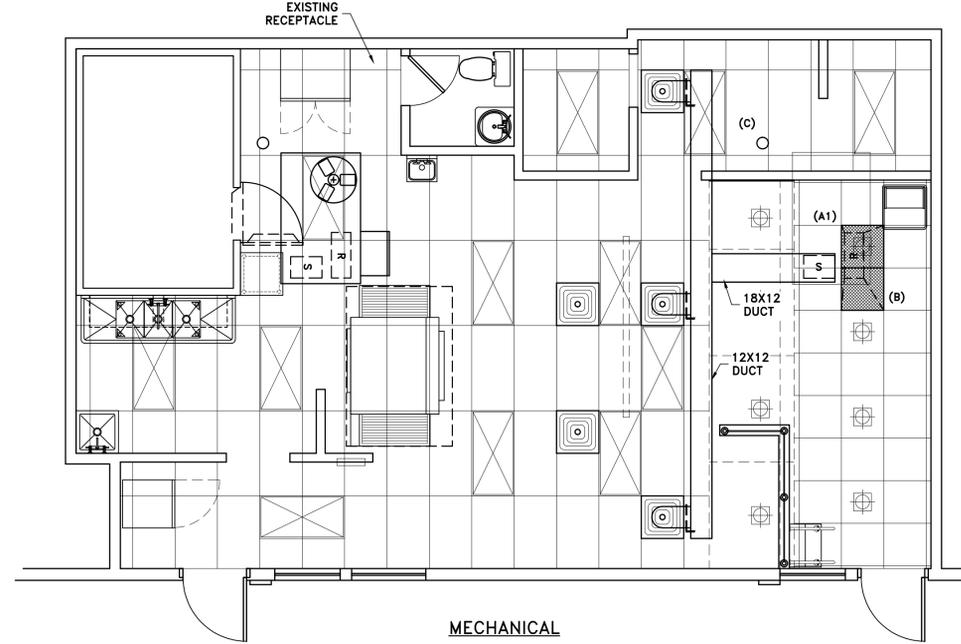


MECHANICAL


NOTE:
AIR BALANCING TO BE DONE BY AN APPROVED METHOD AND A TEST AND BALANCE REPORT MUST BE PROVIDED TO THE HVAC INSPECTOR AT FINAL INSPECTION

- EQUIPMENT**
- (A1) ROOFTOP 150K BTU/4 TON BRYANT (UNIT ON ROOF) 1600 CFM 580JPA1150 6.8 KW 35.6A 208V 1 PH EFFICIENCY = 82% WEIGHT = 700 LBS
 - (B) RETURN GRILL 24X24
 - (C) SQUARE DIFFUSER 24X24 W/ 12" CONNECTION


UTILITY LEGEND
GAS LINE — GAS — GAS

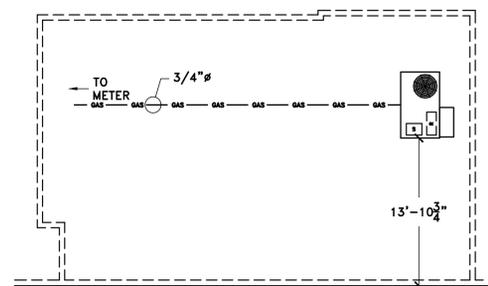


ROOF VIEW
1/8"=1'-0"

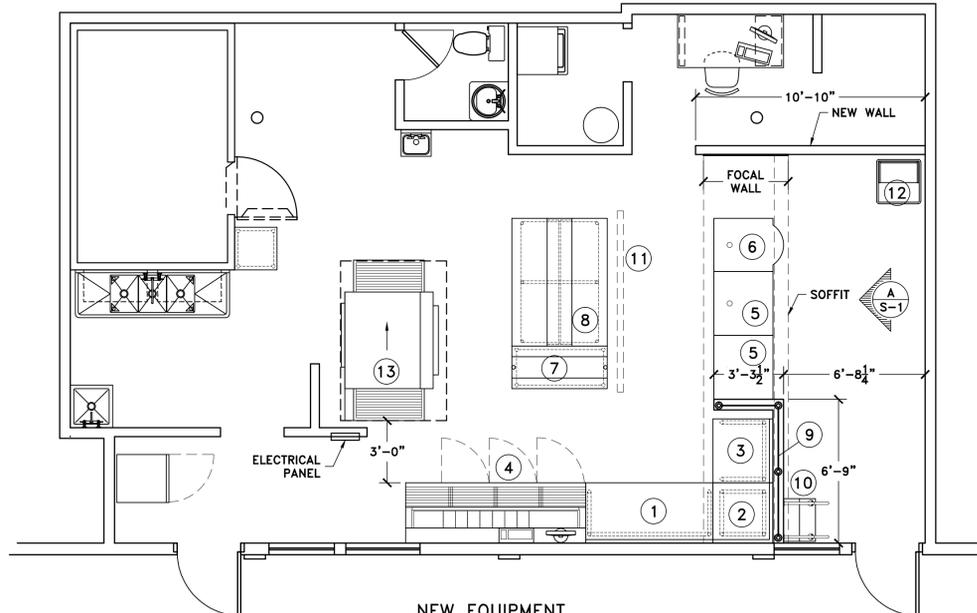


NEW EQUIPMENT

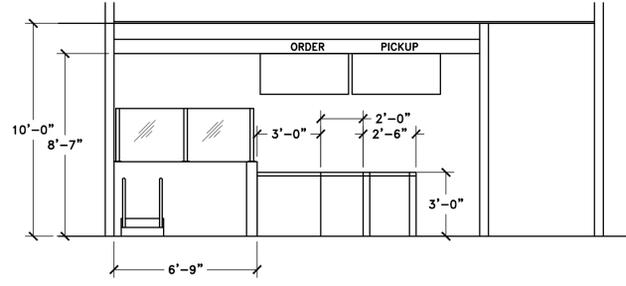


VIEW A-S-1

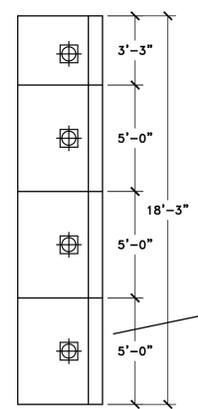

MECHANICAL

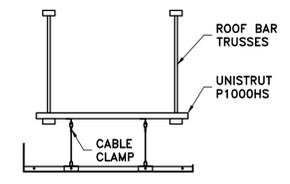

SECTION VIEW HANGING WITH 1/8" CABLE FROM BRACKET AT PANEL SEAMS

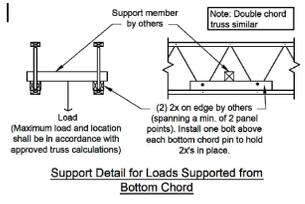

PJ2664-1
Fire Prevention
In: 10/03/2017
Out: 10/07/2017

Full permit- any fire alarm/sprinkler work will require permit/plans to be submitted by sub-contractor to Fire Prevention

Revised
10/09/2017 7:57:20 AM

DWG NO: D051717-1 SCALE: 1/4"=1'-0" REV.

PREPARED FOR
TENANT FINISH AT
255 ANGLERS DRIVE
STEAM BOAT SPRINGS, CO

NET ENGINEERING SERVICES
JOHNSTOWN, CO
970-587-7100 FAX: 970-587-7111

DRAWING DESCRIPTION
REMODEL DETAILS

DATE DRAWN 5/17/17
APPROVED BY
CHECKED BY
DRAWN BY ROSS NICHOLS

DRAWING TYPE
S-1
SHEET OF