



LIGHTING FIXTURE SCHEDULE										
SYMBOL	ITEM	TYPE	MOUNTING HEIGHT	TYPE LAN	MPS COLOR	FIXTURE VOLTAGE	INPUT WATTS	CATALOG NUMBER		
Ю	F1	LED AREA LUMINAIRE	12'	LED	3500	120	54	LITHONIA LIGHTING RAD1-LED-P3-35K-PATH-MVOLT-RPA -DBLXD		
0	F2	WET LISTED DOWNLIGHT	9'	LED	3500	120	8	KEYSTONE TECHNOLOGIES KT-LED8RD-4C-9CSF-DIM		
Ю	F3	WALL SCONCE	7'	LED	3500	120	8	MINKA LAVERY LIGHTING 73370-66-L		

1) FIXTURE SCHEDULE

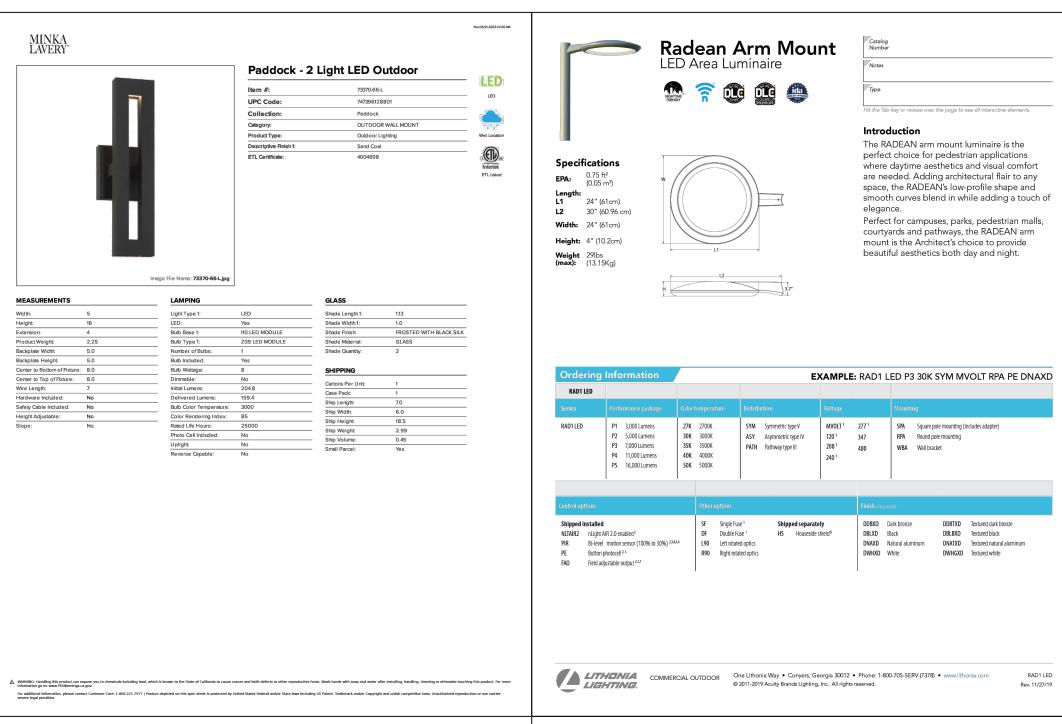

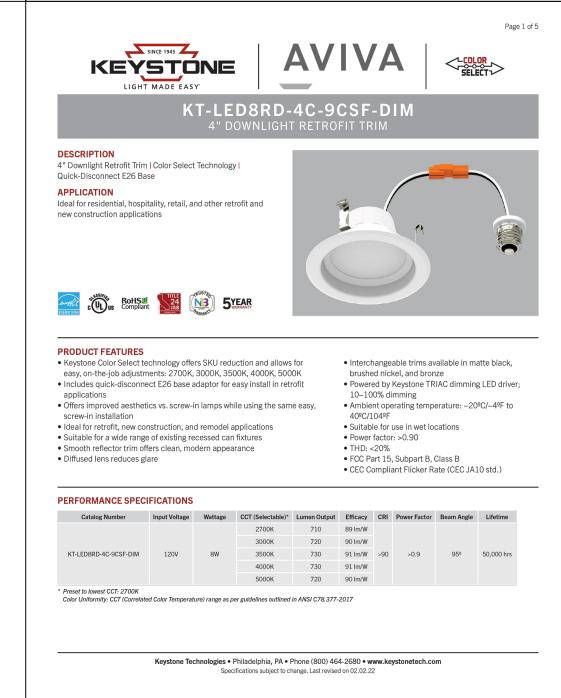



1805 WALTON CREEK TOWNHOMES

Steamboat Springs, CO

STEAMBOAT ARCHITECTURAL ASSOCIATES

PO Box 772910 345 Lincoln Avenue, Ste. 200 Steamboat Springs, CO 80477



Issue	By Date & Issue Description	Ву
	DEVELOPMENT PLAN - 2.21.20	AW
-	DEVELOPMENT PLAN - 6.10.25	AW
	DEVELOPMENT PLAN - 8.7.25	AW

24x36
Description: PHOTOMETRIC
Project Name: 1805 WALTON CREEK
Project Number: 2020007

Scale: 1"=12'-0"

Sheet No.

E1.0