


LIGHTING FIXTURE SCHEDULE							
SYMBOL	ITEM	TYPE	MOUNTING HEIGHT	LAMPS	Fixture	INPUT VOLTAGE	CATALOG NUMBER
○	F1	LED AREA LUMINAIRE	12'	LED	3500	120	54
○	F2	WET LISTED DOWNLIGHT	6"	LED	3500	120	33

① FIXTURE SCHEDULE
NTS

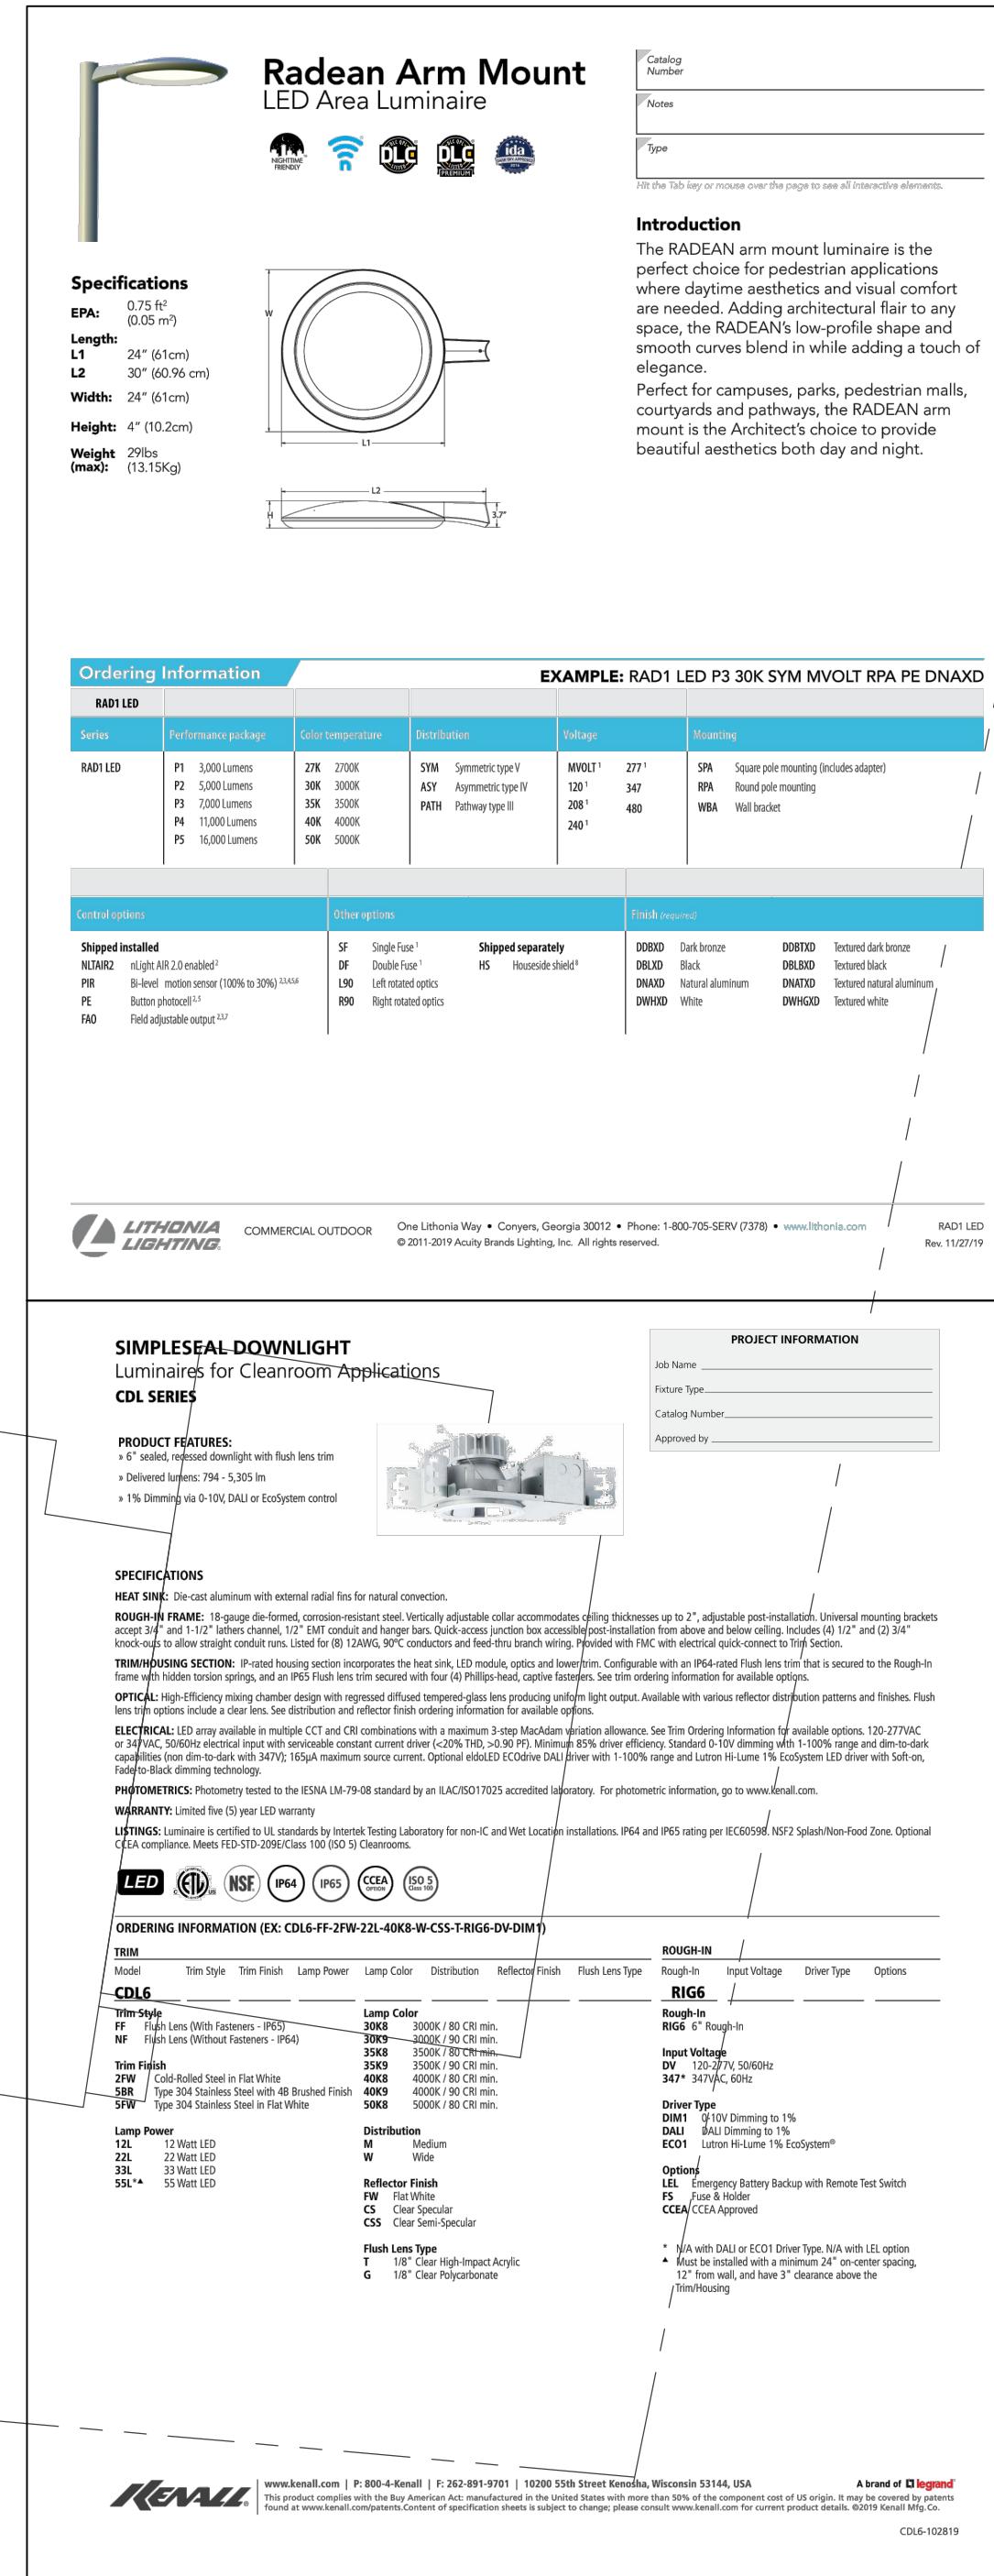


② FIXTURE CUTSHEETS
NTS

STEAMBOAT ARCHITECTURAL ASSOCIATES

PO Box 772910
345 Lincoln Avenue, Ste. 200
Steamboat Springs, CO 80477



WILDER ENGINEERING LLC
Andrew Wilder PE
1170 Blue Sage Drive
Steamboat Springs, CO 80487
P: 970-819-7848
E: andy@wilder-eng.com

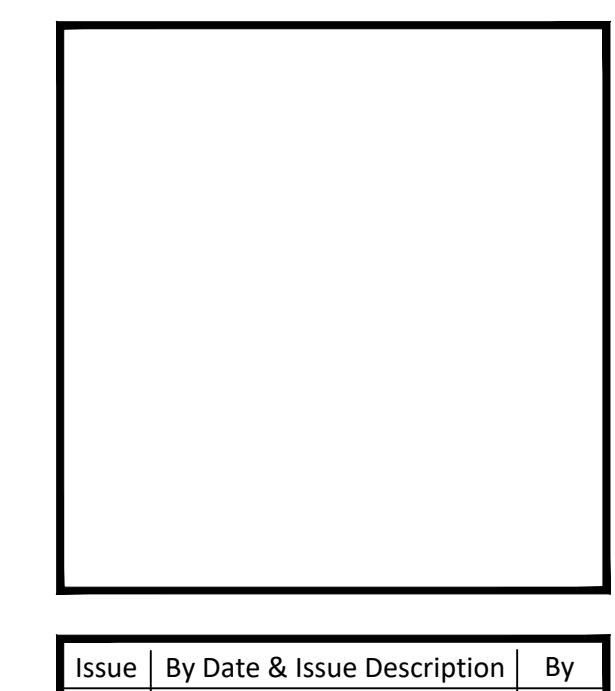

Issue	By Date & Issue Description	By
	DEVELOPMENT PLAN - 2.21.20 [AW]	

Scale:	1'=12'-0"
24x36	
Description: PHOTOMETRIC	
Project Name: 1805 WALTON CREEK	
Project Number: 2020007	
Sheet No.	
E1.0	